 







Downward facing low wattage dusk till dawn lamp to front of properties - (Mounting height to be approx. +2.1m above FFL).




Downward facing low wattage dusk till dawn lamp to rear of properties (Mounting height to be approx. +2.1m above FFL).

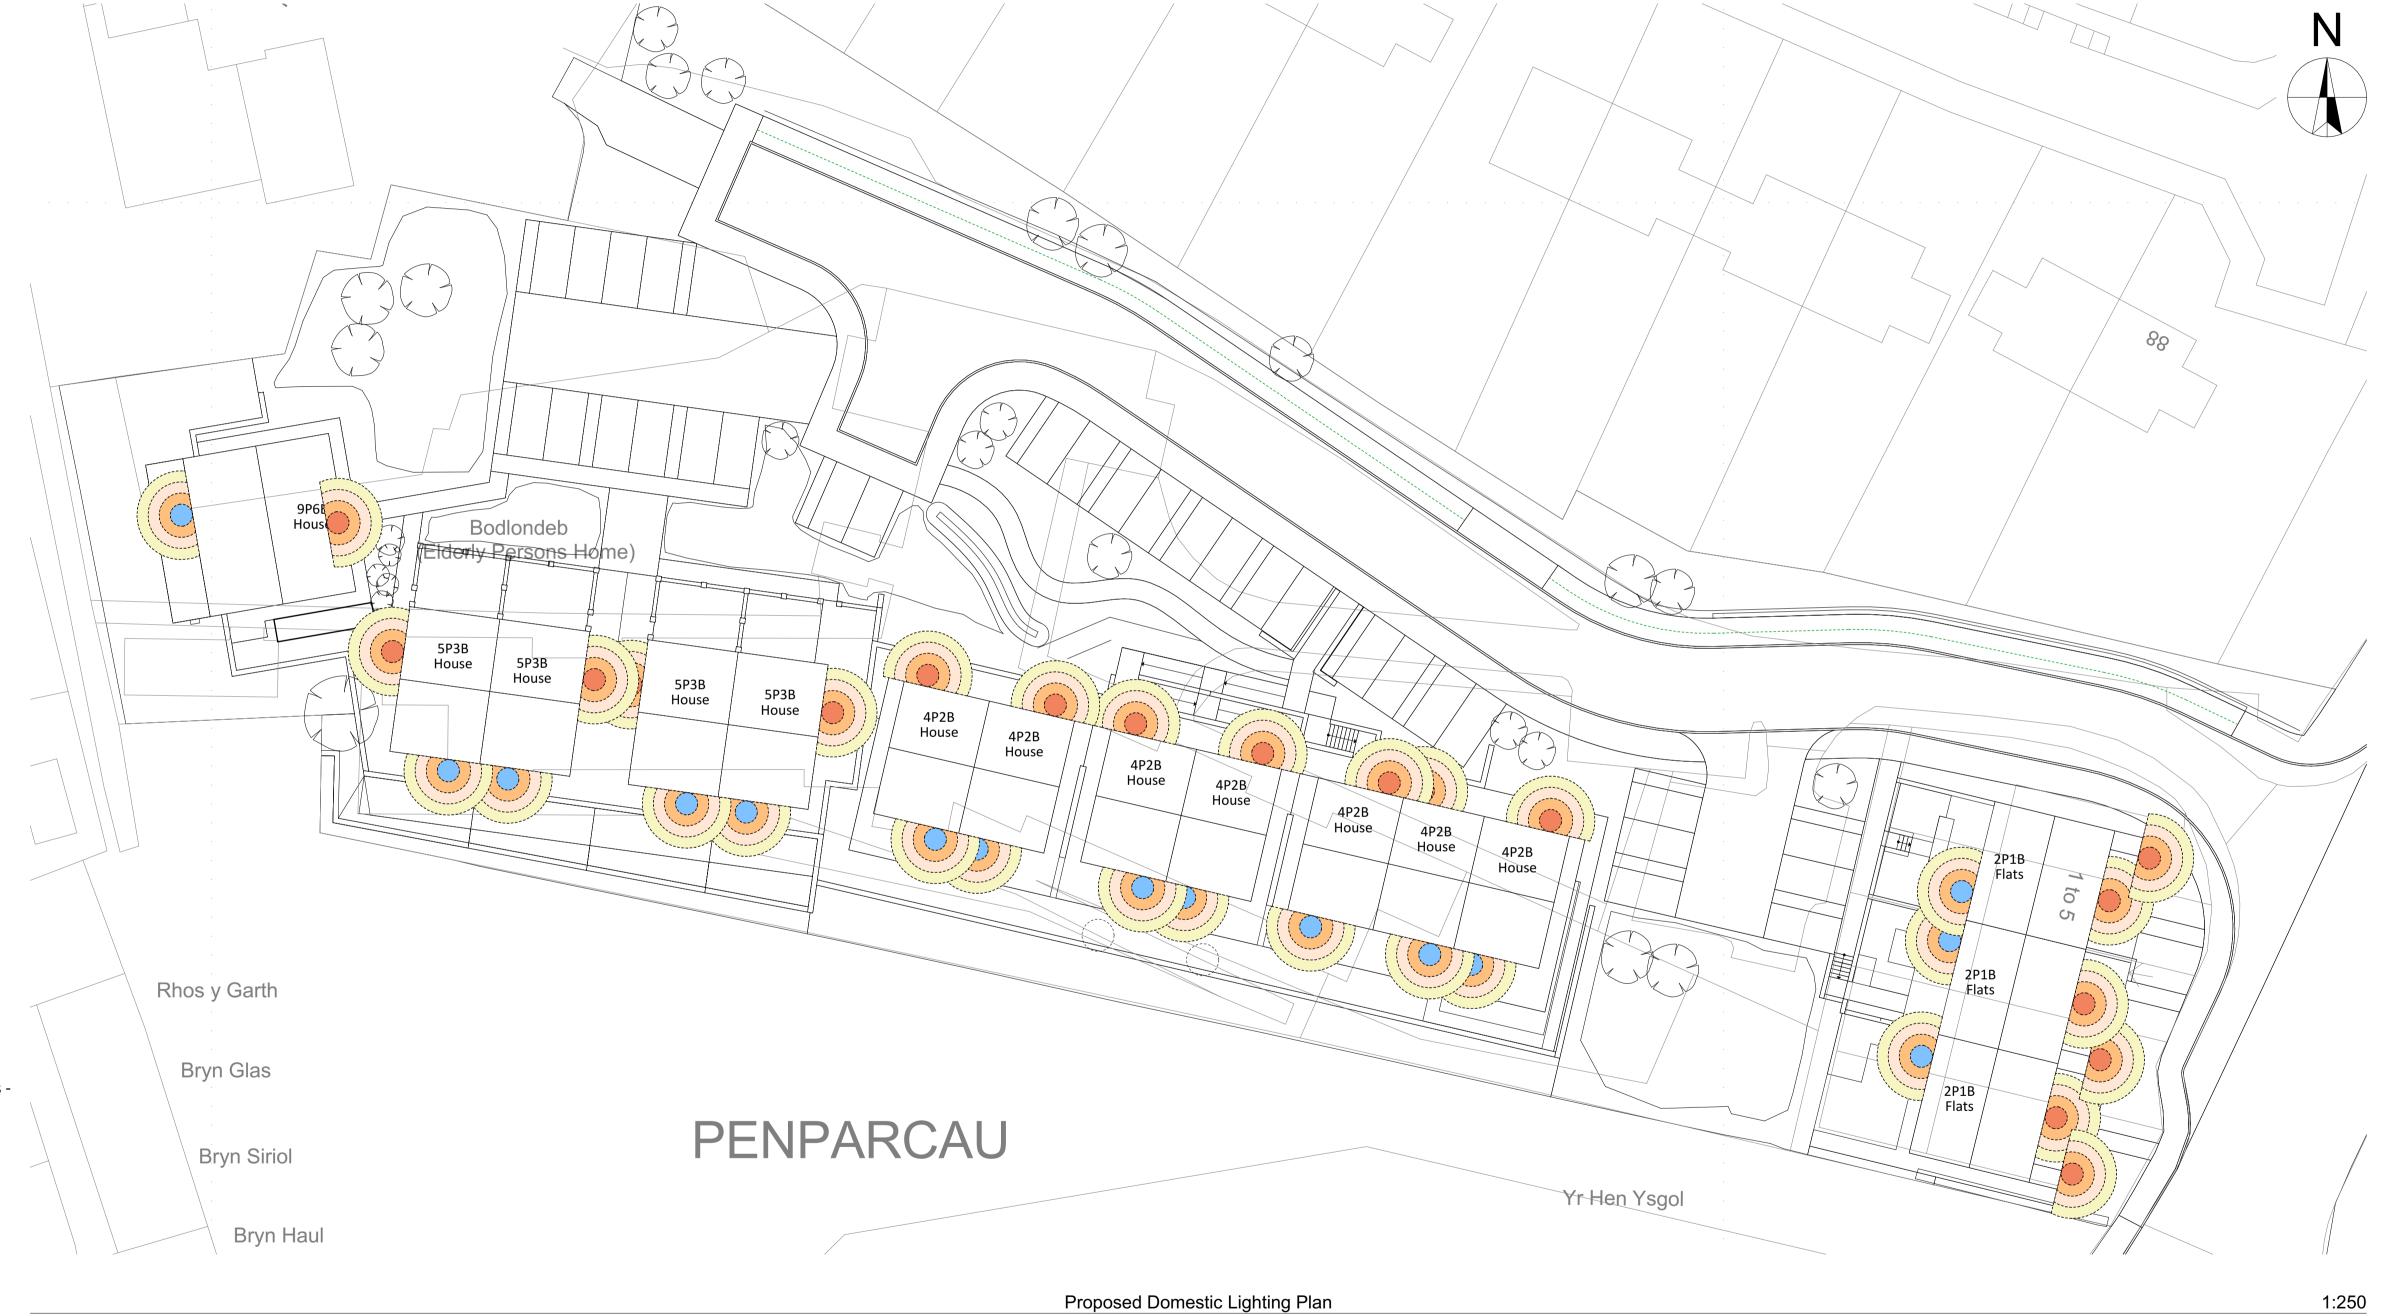

Revision:

Date: By:

Notes:

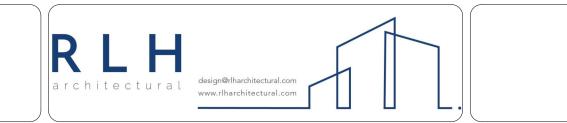



Client:
Tai Wales & West
Housing Association

Scale: Noted
Date: Sept '2
Drawn: SE/RH

Scale: Noted
Date: Sept '23
Drawn: SE/RH

Drawing Title:
PLANNING DRAWINGS Domestic Lighting Plan

Proposed Affordable Housing Development, Former Care Home, Bodlondeb, Penparcau, Aberystwyth, SY23 1SJ